

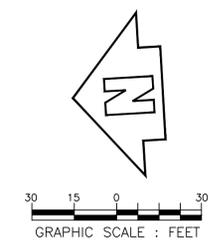


FILENAME: F:\projects\2014\140033 - Gulf Breeze Outfall\CADD\140033C.dwg  
 DATE PLOTTED: 12/10/2014 2:13 PM DRAWN BY: DON PLOT SCALE: 1:

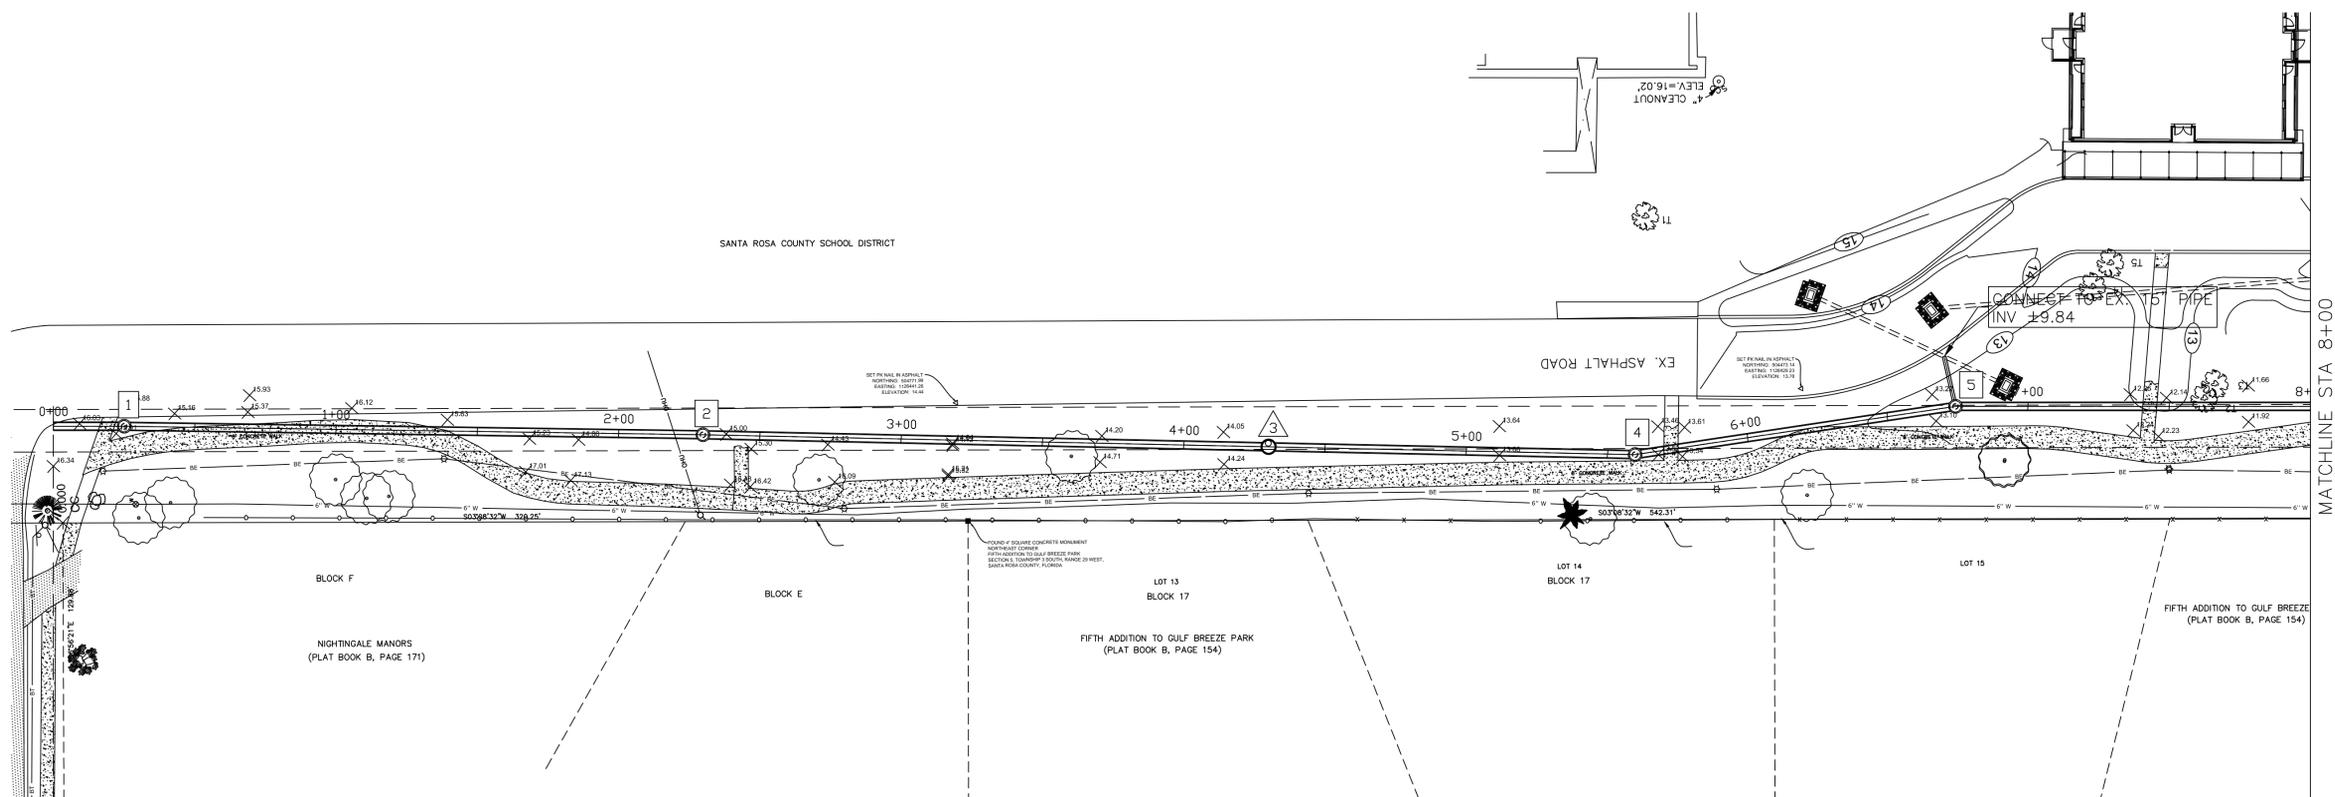

MATCHLINE STA 8+00

- LEGEND**
- ☐ DENOTES TELEPHONE PEDESTAL
  - DENOTES 2' SQUARE BRICK COLUMN
  - DENOTES 1.25' SQUARE CONCRETE TRAFFIC POLE
  - DENOTES FIBER OPTIC CABLE MARKER
  - DENOTES 4" SQUARE, 3.5" TALL, YELLOW METAL POST
  - ⊕ DENOTES FIRE HYDRANT
  - ⊙ DENOTES WATER METER
  - ⊙ DENOTES WATER VALVE
  - ⊙ DENOTES SINGLE POLE SIGN
  - DENOTES WETLAND FLAG
  - DENOTES SOIL BORING
  - ⊙ DENOTES 10" DIAMETER CONCRETE HIGH MAST LIGHT POLE
  - ⊙ DENOTES FLAG POLE
  - ⊙ DENOTES HOSE BIBB
  - ⊙ DENOTES STORM WATER INLET
  - ⊙ DENOTES IRRIGATION CONTROL BOX
  - ⊙ DENOTES WIRE PULL BOX
  - ⊙ DENOTES ORNAMENTAL LIGHT POLE
  - ▨ DENOTES CONCRETE
  - ▨ DENOTES ASPHALT
- RCP DENOTES REINFORCED CONCRETE PIPE
  - CMP DENOTES CORRUGATED METAL PIPE
  - CPF DENOTES CORRUGATED PLASTIC PIPE
  - INV DENOTES INVERT
  - EL DENOTES ELEVATION
  - W/ DENOTES WITH
  - LB DENOTES LICENSED BUSINESS
  - FFE DENOTES FINISHED FLOOR ELEVATION
  - BFP DENOTES BACK FLOW PREVENTER
  - DENOTES IRON FENCE
  - DENOTES CHAIN LINK FENCE
  - DENOTES SOLID WHITE LINE
  - DENOTES SOLID YELLOW LINE
  - ↷ DENOTES TURN ARROW

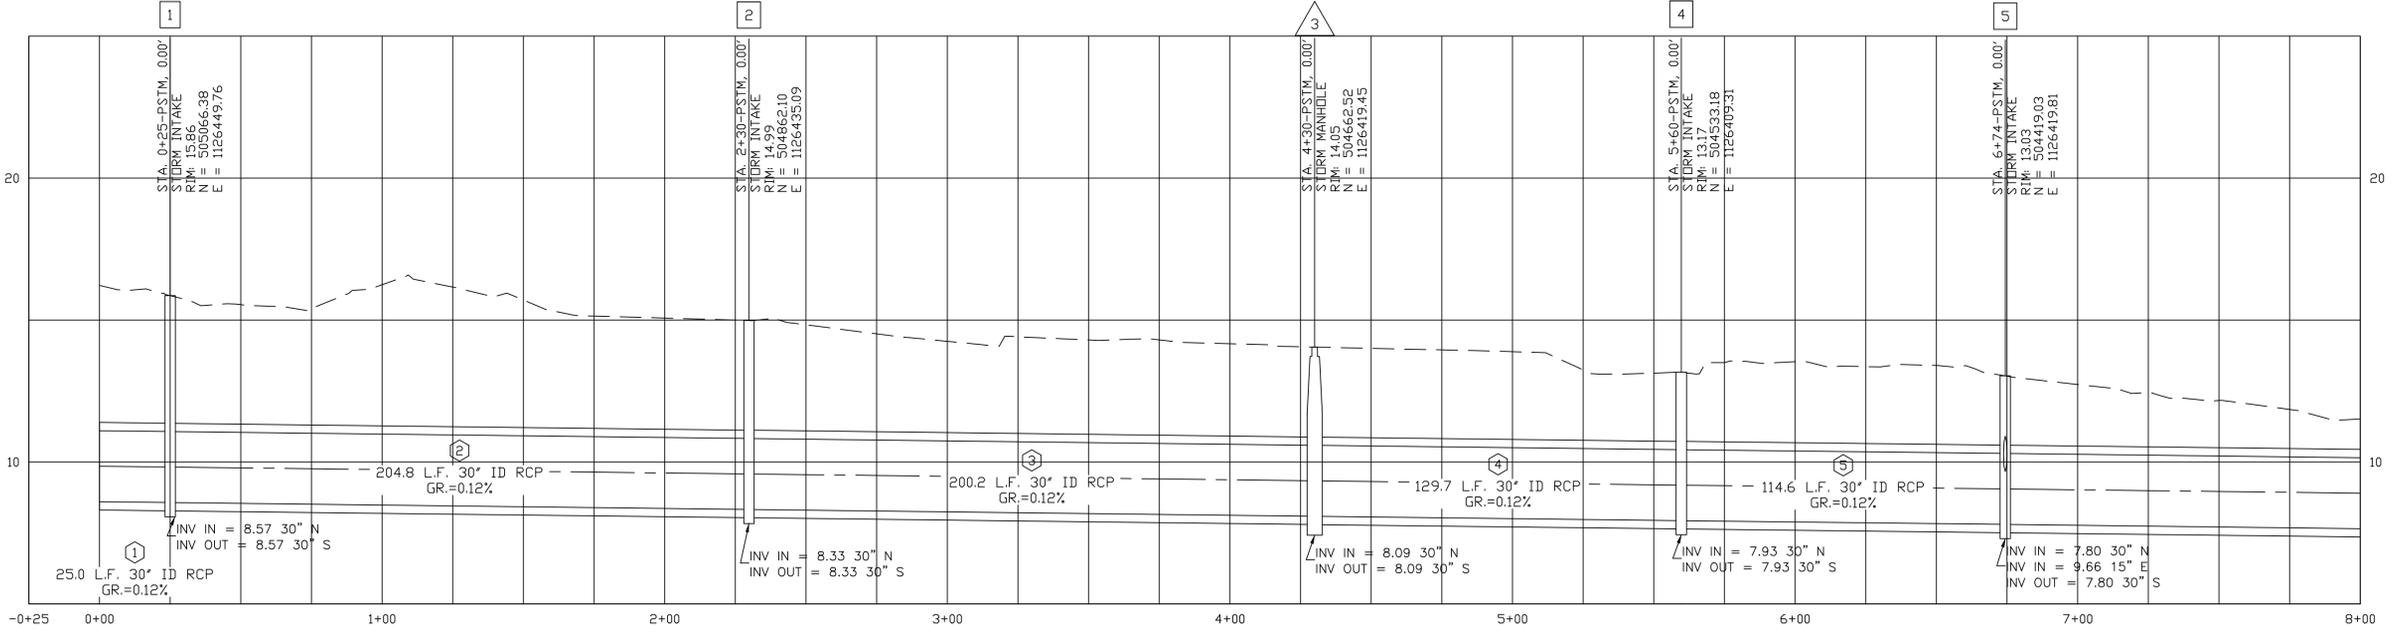

**jhi jehle-halstead, inc.**  
 Civil Engineering and Surveying  
 5414 Highway 90 Milton, Florida 32571  
 (850) 994-5903 Fax (850) 994-9504  
 www.jehle-halstead.com  
 Certificate of Authorization No. 0000489  
 Surveying License Number 037403

**NIGHTINGALE MANORS  
 OUTFALL**  
 CITY OF GULF BREEZE ~ FLORIDA

**OUTFALL PLAN AND PROFILE  
 STA 0+00 TO STA 8+00**

DONALD P. JEHL, PE  
 #23889

Revisions	
Date	Description

Designed By: DPJ  
 Drawn By: TAH  
 Checked By: DPJ  
 Job No.: 140033  
 Date: NOVEMBER 14  
 Scale: 1" = 30'  
 Sheet No.: 1